Side Elevation 2

 
4 Side El A-500 1/8" = 1'-0"



EXTERIOR FINISH SCHEDULE CALLOUT PATTERN MATERIALS DESCRIPTION VintageBrick Nichiha Brick Manuf: Nichiha Color: Alexandria Buff VintageWood 2 Nichiha Wood Manuf: Nichiha Color: Spruce Latura V-Groove Nichiha Latura 3 Manuf: Nichiha V-Groove Color: Gray Trim Board 4 Trim Board Manuf: TBD Color: Gray Trim Board 5 Trim Board Manuf: TBD Color: Gray Glazing: As Specified Texture: Smooth Color: As Specified .090 Aluminum Metal Alum. Break Manuf: Valspar Color: Fluropo - Colonial Red

- A. IMPORTANT! Before final ordering of materials, coordinate color schemes with architect via use of exterior elevations in color!
- B. Refer to written specifications for futher requirements for each exterior finish listed above, including finishes for doors and windows.
- C. ALL adjacent copings, flashings and trim shall match main field color area material (U.N.O), final selection shall be by architect from physical samples of metal flashings
- D. ALL materials on exterior finish sheedule shall be selected from manufacturer's <u>FULL</u> range of colors unless otherwise noted above.
- E. ALL items mounted in masonry veneer shall receive the proper pre-manufactured trim stone or precast concrete (for items including but not limited to light fixtures, electrical outlets, plumbing fixtures, etc.) Some items may not require trim stones if boxes are concealed behind fixtures and fixtures sit plumb and level against masonry. Coordinate items in question with the Architect.
- F. ALL exterior dis-similar materials shall be caulked weather tight with silicone caulk, color to match adjacent materials. Contractor shall coordinate all colors selection of caulk to be used on the job with the Architect using elevations for location and application.





7.0.Wall 38' - 6"

B.O.Roof 36' - 4"

25' - 8"

03_Third Floor

02_Second Floor 15' - 0"

 
01_First Floor 0' - 0"

T.O.Wall 38' - 6"

B.O.Roof 36' - 4"

03_Third Floor 25' - 8"





DRAWING NAME: Exterior **Elevations**

Drawn By: Checked By: DRAWING NO.


01_First Floor 0' - 0"

Project Status SCHEMATIC DE REVISIONS: No. Descript

Project No: XX.XXX

(3 (X-500) 1/8" = 1'-0"

T.O.Wall 38' - 6" B.O.Roof 36' - 4" 03_Third Floor 25' - 8" 02_Second Floor 15' - 0" 01_First Floor 0' - 0" Side Elevation 2_Transparancy X-500 Total: 4820 sqft Opening: 1338 sqft Percentage: 28% T.O.Wall 38' - 6" B.O.Roof 36' - 4" 3rd Floor: Total: 1415 sqft Opening: 342 sqft Percentage: 24% __03_Third Floor 25' - 8" 2nd Floor: Total: 1415 sqft Opening: 342 sqft Percentage: 24% 02_Second Floor 15' - 0" 1st Floor: Total: 1990 sqft Opening: 684 sqft Percentage: 35% 01_First Floor 0' - 0" Side Elevation 1_Transparancy

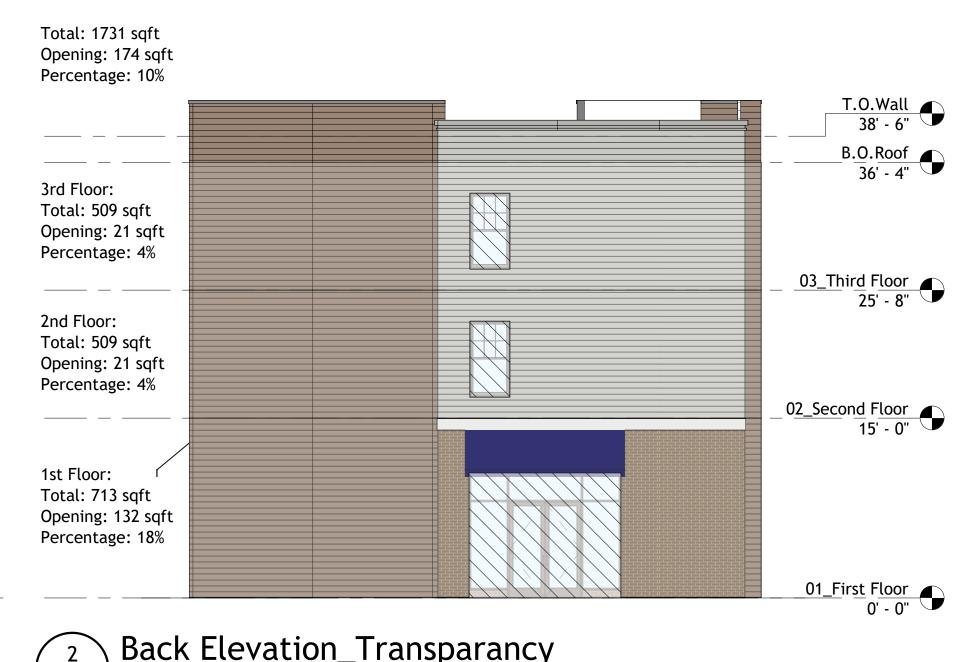

Back Elevation_Transparancy X-500



Front Elevation_Transparancy X-500 1/8" = 1'-0"

DRAWING NAME: **Exterior Elevations**

SCHEMATIC DESIGN-

Project Status

REVISIONS: No. Description

Drawn By: Checked By: DRAWING NO.

Issue Date

Author

Project No: XX.XXX